
r		
chall be without lichtitty to Kimilev-Horn and Accordinates lac		
000		
2		
L L		
<u>×</u>		
(+ +		
+:::40		
+		
Cd+iw	_	23.07
D L		
	· ·	
400		
		1
ن < ح		
ç		
ЦОЧ		
,		
2		
adantation by Kimlev-Horn and Accordates loc		
		(C)
		(C)
tted By:Kleine, David Sheet Set:Kha Layout:C-110 SITE PLAN January 29, 2025 08:18:01am K:\LAK_Civil\046376020 - Lunz Caloosa Lake Fire Station\CAD\PlanSheets\C-110-SITE.dwg		.73
1000		326.73
t		
vg 70++i7		÷ E
E.dv		00°11'30"
- SIT		11.
110-		
		S
ets/		
She		
Plan		-
AD		
C/C		
impr		
Sto		
Fire of		
ake		
SOOS		
Cal		Ť
zunz		
		(F)
)20 for		î.
176C		656.7
0463		651
		E
- Ci		<i>.</i> 0
LAK		00°11'30" 3)
∠∠		(
		S 0 (C)
)1an , for		
18:(330.04
08: 74ad		3
55		μ
202		:0
29,		00°11'30"
Jr y		1.00
anuc		S
LAN ;		
H H		
SI1	1	40.0'
-110 -		
t: C-		
you:	ı 	
La		
ru vy vy		
set: +		
et o]	
She		
+ + + -		
Davi		
ne,		у , У
× ===		
By:		
eq		

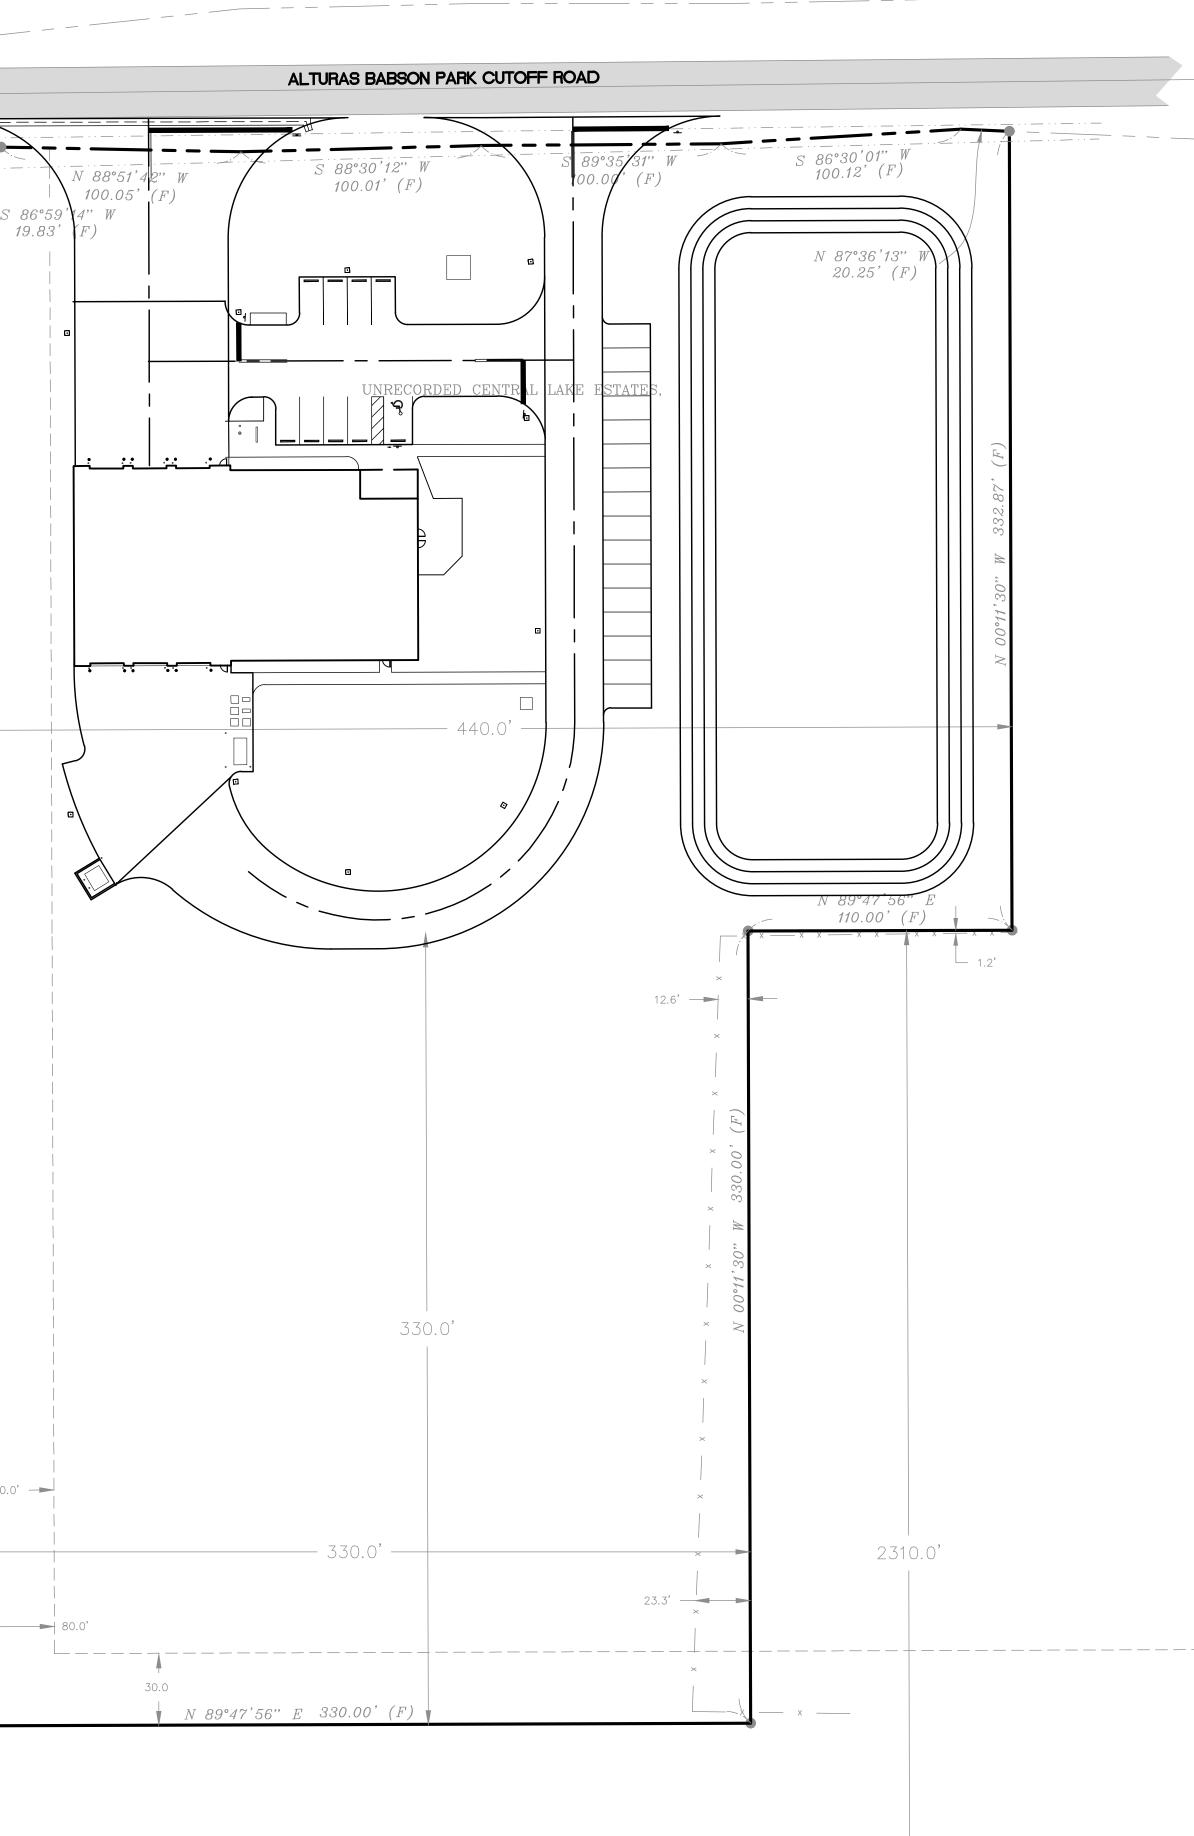

					DATE BY			
					No. REVISIONS			
	WWW.KIMLEY-HORN.COM REG NO.: 35106							
LICENSED PROFESSIONAL	PE NAME		FLORIDA LICENSE NUMBER	PE NUMBER	- DATE: JAN 29 2025			
KHA PROJECT 046376020	DATE Jan 2025	SCALE AS SHOWN	DESIGNED BY -	DRAWN BY -	СНЕСКЕД ВҮ —			
CALOOSA LAKE	FIRE STATION			I HE LUNZ GHOUP	POLK COUNTY FLORIDA			
SHEET NUMBER								

NORTH GRAPHIC SCALE IN FEET 0 20 40 80