


Plumbing / Electrical Plan


- Electrical and Plumbing Notes:
- All electrical work shall be performed in accordance with the 2017 NEC.
 - All electrical work shall be performed by a licensed, certified electrician.
 - All plumbing work shall be performed by a licensed, certified plumber.

Note:
Final size and location of water tank / tower per licensed contractor.

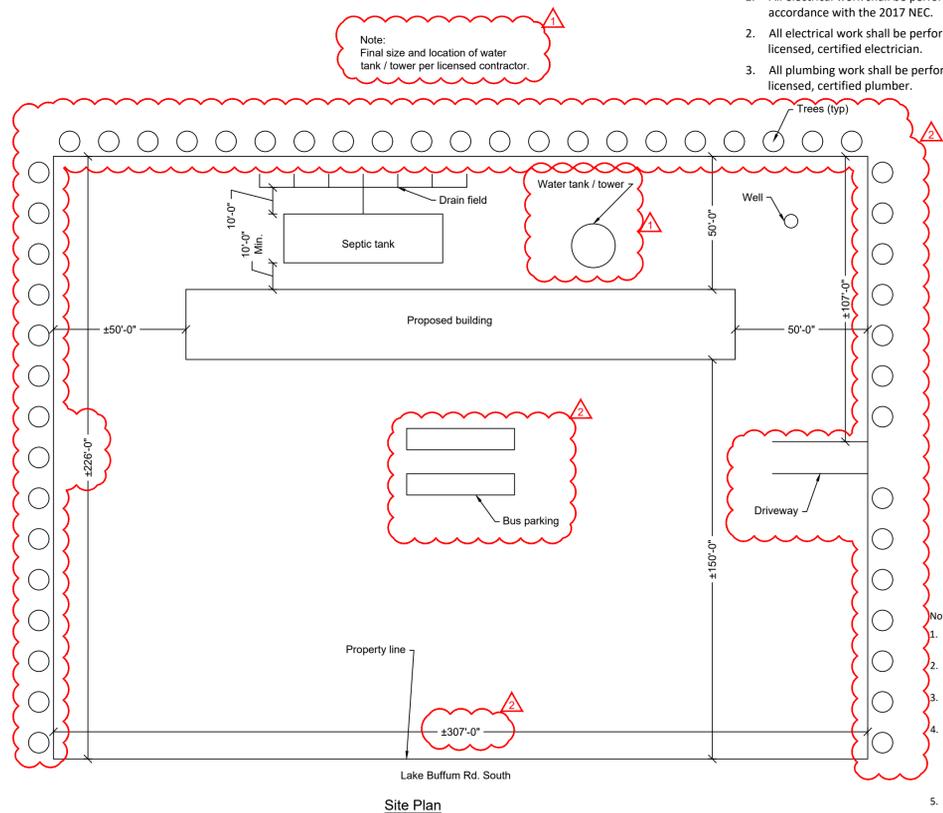

Site Plan

- Notes:
- Percolation rate to be determined by others.
 - Septic tank to be 1500 gallon tank (min).
 - Drain and leach fields to be sized per percolation rate.
 - Septic tank, drain field and leach field to be sized and installed per FBC 2020 7th Edition by a licensed professional.
 - Well location and size per licensed contractor.

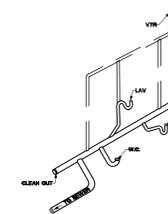




Generic Plumbing Riser

No.	Date	Description	By	Chk
1	08/03/23	Added Sprinkler System & Tank / Tower	RJD	KMB
2	10/13/23	Added Driveway and Dimensions of Site Plan	RJD	KMB


Electric Symbol Legend

	Outside Light
	Ceiling Light
	Switch
	GFI Outlet
	Outlet
	Ceiling Fan (Optional)
	Smoke / Carbon Monoxide Detector



SAFE UPLIFT LOADS FOR 8" PRECAST & PRESTRESSED U-LINTELS				SAFE UPLIFT LOADS FOR 8" PRECAST & PRESTRESSED U-LINTELS			
MARK NO.	LENGTH	TYPE	SAFE LOAD - POUNDS PER LINEAR FOOT	MARK NO.	LENGTH	TYPE	SAFE LOAD - POUNDS PER LINEAR FOOT
M-1	3'-6" (42")	PRECAST	2231	N-1	3'-6" (42")	PRECAST	1969
M-2	4'-0" (48")	PRECAST	1966	N-2	4'-0" (48")	PRECAST	1683
M-3	4'-6" (54")	PRECAST	1599	N-3	4'-6" (54")	PRECAST	1327
M-4	5'-0" (60")	PRECAST	1217	N-4	5'-0" (60")	PRECAST	1016
M-5	5'-6" (66")	PRECAST	1062	N-5	5'-6" (66")	PRECAST	899
M-6	6'-0" (72")	PRECAST	908	N-6	6'-0" (72")	PRECAST	772
M-7	7'-0" (84")	PRECAST	743	N-7	7'-0" (84")	PRECAST	635
M-8	8'-0" (96")	PRECAST	588	N-8	8'-0" (96")	PRECAST	498
M-9	10'-0" (120")	PRECAST	475	N-9	10'-0" (120")	PRECAST	402
M-10	11'-0" (132")	PRECAST	362	N-10	11'-0" (132")	PRECAST	289
M-11	12'-0" (144")	PRECAST	337	N-11	12'-0" (144")	PRECAST	264
M-12	13'-0" (156")	PRECAST	296	N-12	13'-0" (156")	PRECAST	239
M-13	14'-0" (168")	PRECAST	279	N-13	14'-0" (168")	PRECAST	222
M-14	14'-0" (176")	PRESTRESSED	N.R.	N-14	14'-0" (176")	PRESTRESSED	N.R.
M-15	15'-0" (184")	PRESTRESSED	N.R.	N-15	15'-0" (184")	PRESTRESSED	N.R.
M-16	17'-0" (204")	PRESTRESSED	N.R.	N-16	17'-0" (204")	PRESTRESSED	N.R.
M-17	19'-0" (222")	PRESTRESSED	N.R.	N-17	19'-0" (222")	PRESTRESSED	N.R.
M-18	21'-0" (254")	PRESTRESSED	N.R.	N-18	21'-0" (254")	PRESTRESSED	N.R.
M-19	22'-0" (264")	PRESTRESSED	N.R.	N-19	22'-0" (264")	PRESTRESSED	N.R.
M-20	24'-0" (288")	PRESTRESSED	N.R.	N-20	24'-0" (288")	PRESTRESSED	N.R.

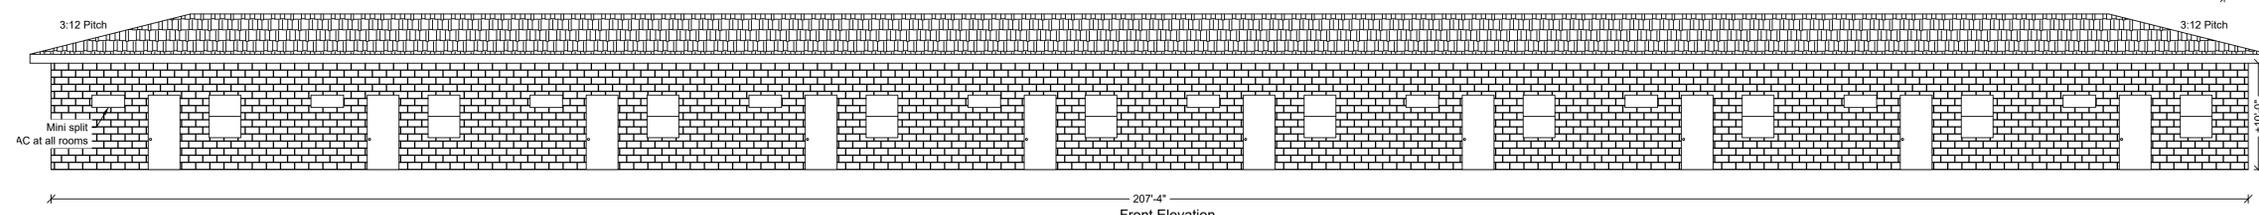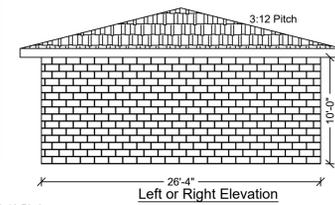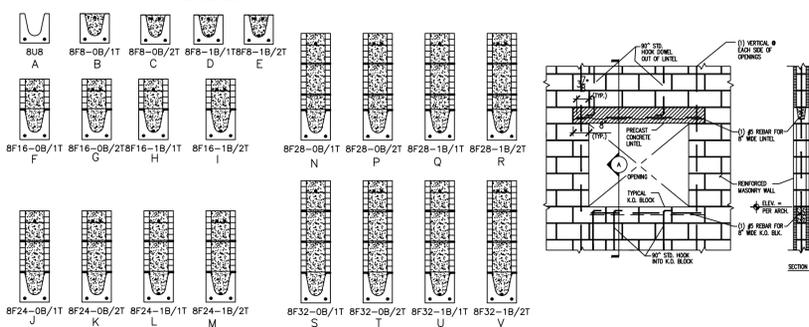

Front Elevation

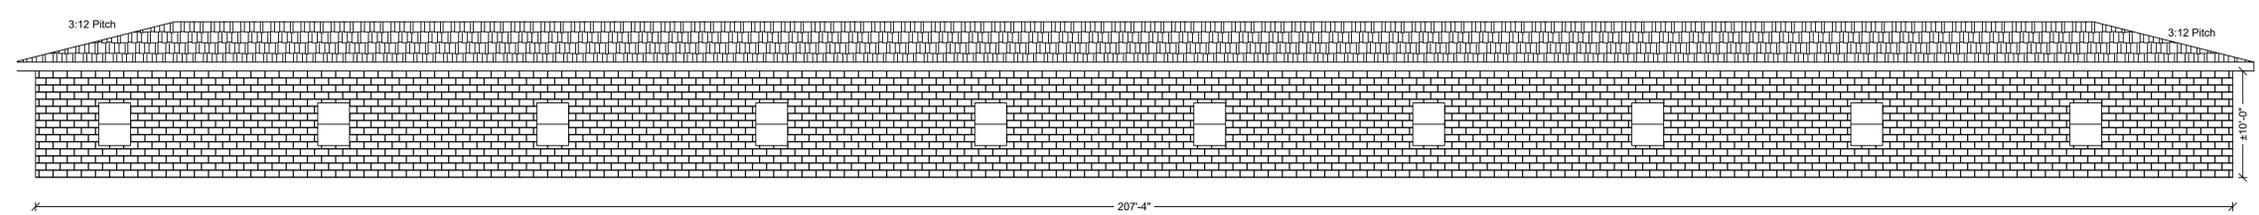

Rear Elevation

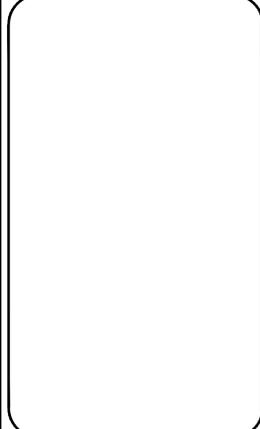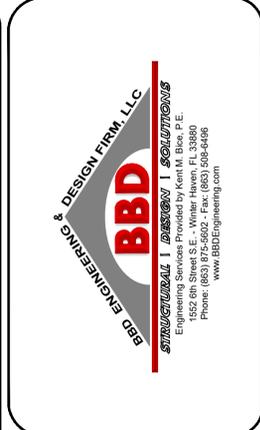

PROJECT INFORMATION:
PREPARED FOR:
Integrity Permit Solution, LLC

PROJECT NAME:
0 Doc Lindsey
Fort Meade, FL

JOB NUMBER:
E03009-23

DATE:
05/11/23

DRAWN BY:
RJD

CHECKED BY:
KMB

SCALE:
NTS

SHEET NUMBER:
D-2